


ELECTRICAL SITE PHOTOMETRIC PLAN

SCALE: 1=30'-0"

1

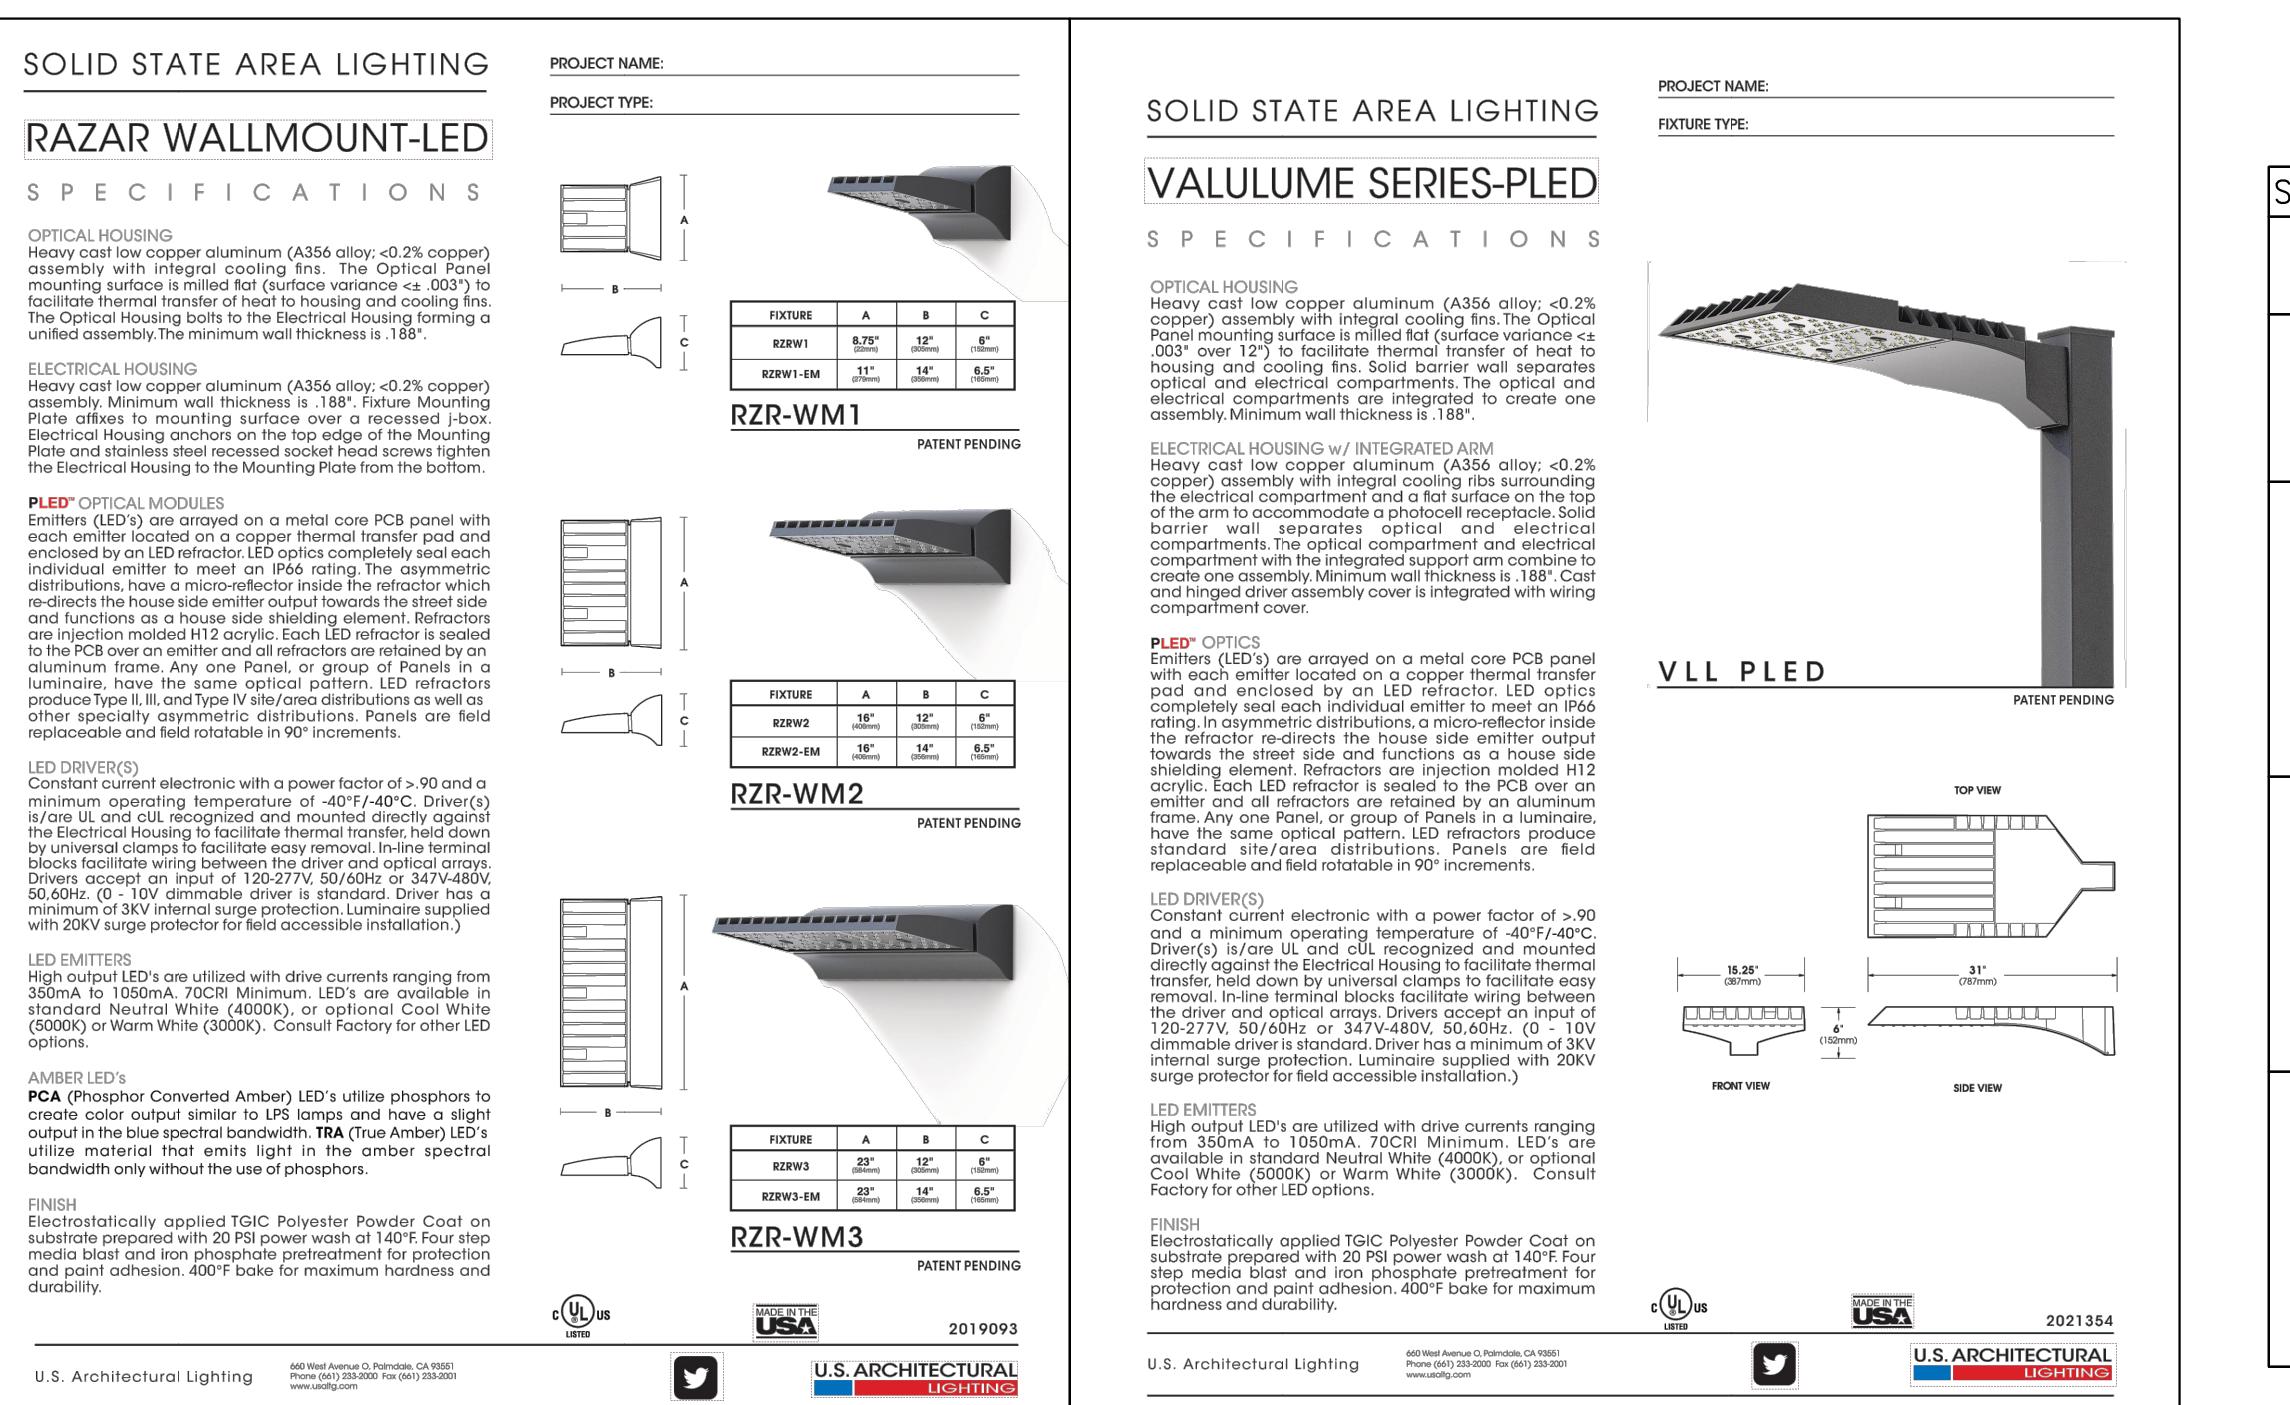

Schedule									
Symbol	Label	QTY	Catalog Number	Description	Lamp	Number Lamps	Lumens per Lamp	ULF	Wattage
☒	W3	12	RZB-WM1-PLED-III-W-20LUMA-350mA-27K-EM1	CAST BLACK PAINTED FINNED METAL HOUSING.	20 WHITE LIGHT EMITTING DIODES (LEDS), BASE UP.	20	151	0.9	21.4
☒	W1	8	VLL-PLED-IV-FT-BOLDED-700mA-27K-WALL MT AT 25 FT AFG BUG RATING B3 UO G3 MM51	CAST BLACK PAINTED FINNED METAL HOUSING.	80 WHITE LIGHT EMITTING DIODES (LEDS), BASE UP.	80	197	0.9	173.6
☐	SA3	2	VLL-PLED-III-W-80LED-525mA-27K-HS-POLE MT AT 25 FT AFG BUG RATING B1 UO G3 25 FT POLE 2.5 FT BASE MM51	CAST BLACK PAINTED FINNED METAL HOUSING.	80 WHITE LIGHT EMITTING DIODES (LEDS), BASE UP.	80	147	0.9	129.4
☐	SA2	3	VLL-PLED-III-W-80LED-525mA-27K-HS-POLE MT AT 25 FT AFG BUG RATING B1 UO G3 25 FT POLE 4 FT BASE MM51	CAST BLACK PAINTED FINNED METAL HOUSING.	80 WHITE LIGHT EMITTING DIODES (LEDS), BASE UP.	80	147	0.9	129.4

Statistics								
Description	Symbol	Avg	Max	Min	Max/Min	Avg/Min		
Calc Zone #1	+	2.0 fc	6.7 fc	0.1 fc	67.0:1	20.0:1		
Calc Zone #2	+	2.4 fc	4.5 fc	0.8 fc	5.6:1	3.0:1		
Calc Zone #3	+	2.1 fc	3.1 fc	1.1 fc	2.8:1	1.9:1		

RGA PROJECT NO:	21069.00
CAD FILE NAME:	21069-00-A1-01
DRAWN BY:	
CHK'D BY:	
COPYRIGHT:	
SHEET TITLE:	SITE PHOTOMETRIC PLAN
MARK:	03/15/21
DATE:	CONCEPTUAL SITE PLAN

BREW HARLEY KNOX

HARLEY KNOX BLVD, PERRIS, CA



FC-1.0

10/28/2022

03/15/21	CONCEPTUAL SITE PLAN
MARK	DATE
	DESCRIPTION

RPM#22-xxx

10/28/2022